


PL202200067

0.25 fc

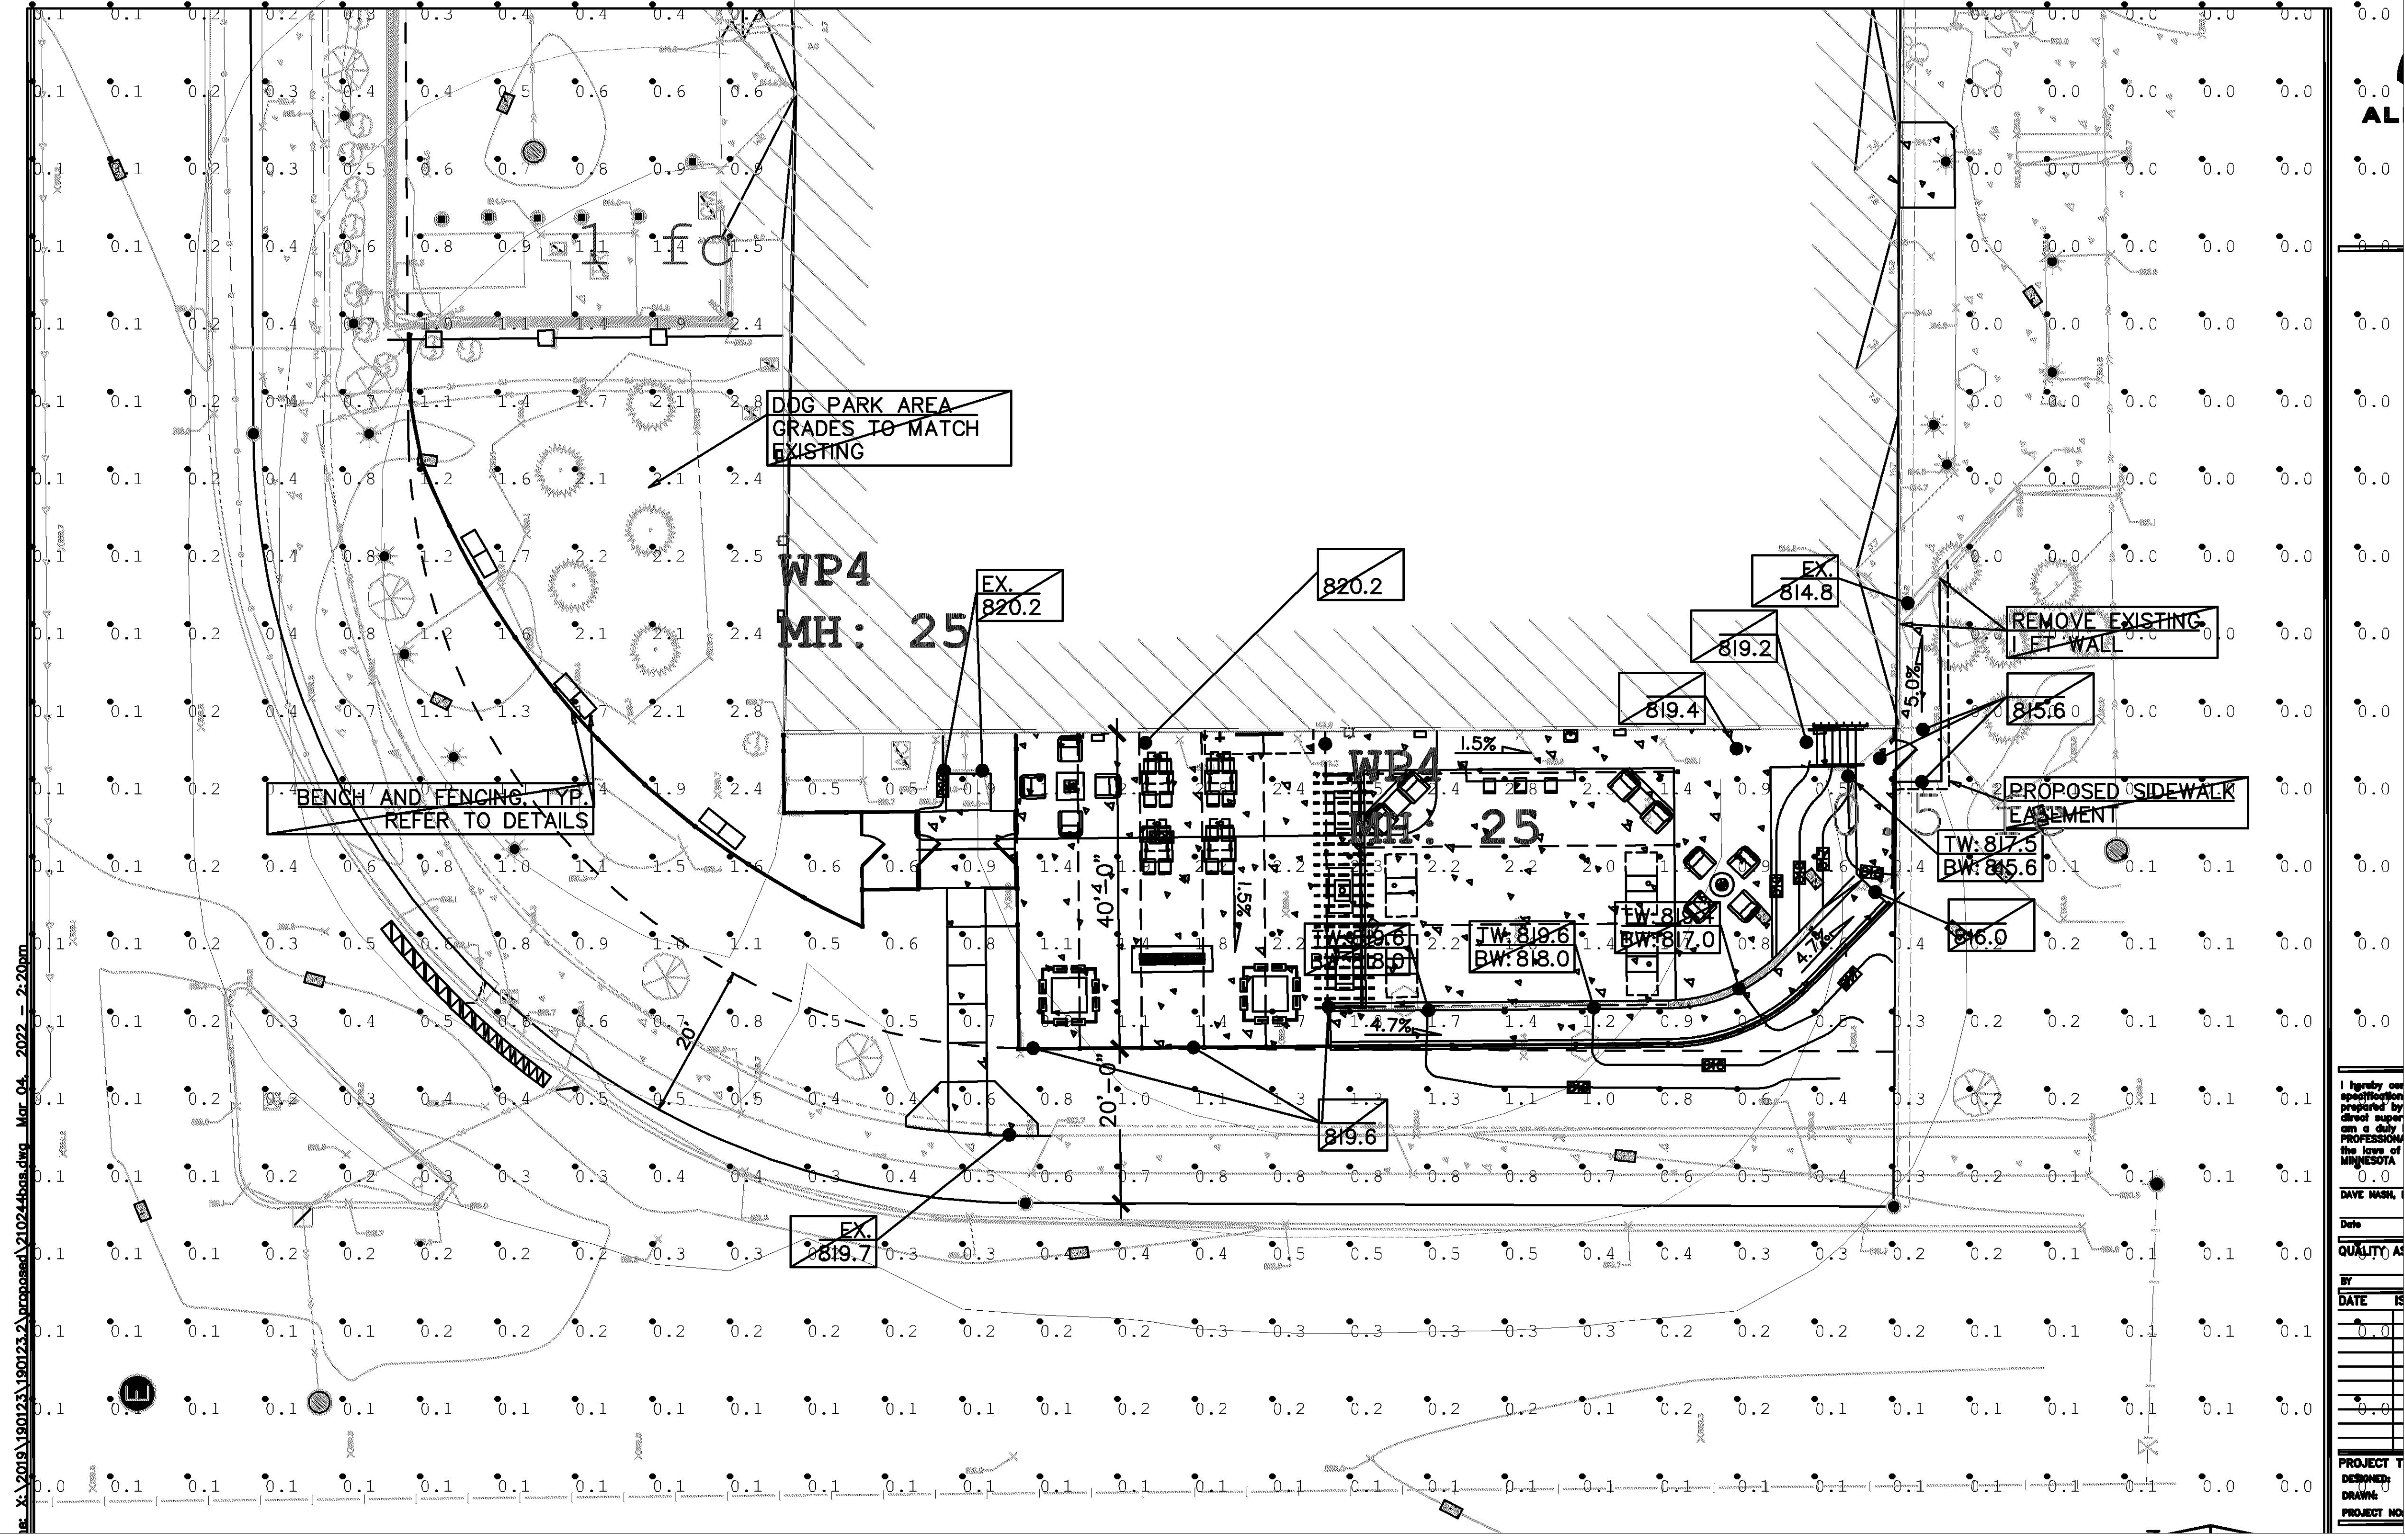

Calculation Summary

Label	Ground	Planar	Luminaire Schedule										
Symbol	Qty	Label	Label	Arrangement	LLF	Description	Avg	Units	Avg	Max	Min	Avg/Min	Max/Min
	2	WP4	SINGLE	0.810	0.24	PRV-C60-D-UNV-T4-BZ	0.810	Fc	0.24	2.8	0.0	N.A.	N.A.

Aire Hotel and Apartments

Page M of 1

Drawn By: Daniel Budke
Checked By:
Date: 3/18/2022

Scale:

Revisions

