


A LEBELLE Company
cmta.com | 877 380 0500


cmta.com | 877.500.0000

Schedule									
Symbol	Label	QTY	Manufacturer	Catalog	Description	Number Lamps	Lamp Output	LLF	Input Power
□ □	AA1	12	BEGA North America	99596	Roadway luminaire	1	9342.636	0.81	76.3
□ □	AA3	6	BEGA North America	99599	Roadway luminaire	1	13262.99	0.81	115.4
○	BB1	35	BEGA Converted by LUMCat V 18.04.2017 / M.S.		84063K3	1	1363.389	0.81	23
□	WW1	4	BEGA-US	22 132	CAST ALUMINUM HOUSING, TRANSLUCENT WHITE GLASS ENCLOSURE WITH STAINLESS STEEL FACE PLATE.	1	90.81557	0.81	11.5
—	Z6	4	Lithonia Lighting	WPX1 LED P2 40K Mvolt	WPX1 LED wallpack 3000lm 4000K color temperature 120-277 Volts	1	2912.845	0.81	24.42
—	LE1	218	Senso Lighting	455-405-FS-MO-35-XX- XX-1'	Trident IP	2	340.9987	0.81	3.751
○	LE2	6	3G LIGHTING-TORONTO.ONTARIO	3G-DL33RA-10-S80-35K--60D-SDF60	DL33RA DOWNLIGHT (3.3 INCH ROUND ADJUSTABLE)	1	830	0.81	10.26
○	BB2	11	BEGA Converted by LUMCat V 17.07.2017 / H.R.		84063K3	2	1363.389	0.81	66

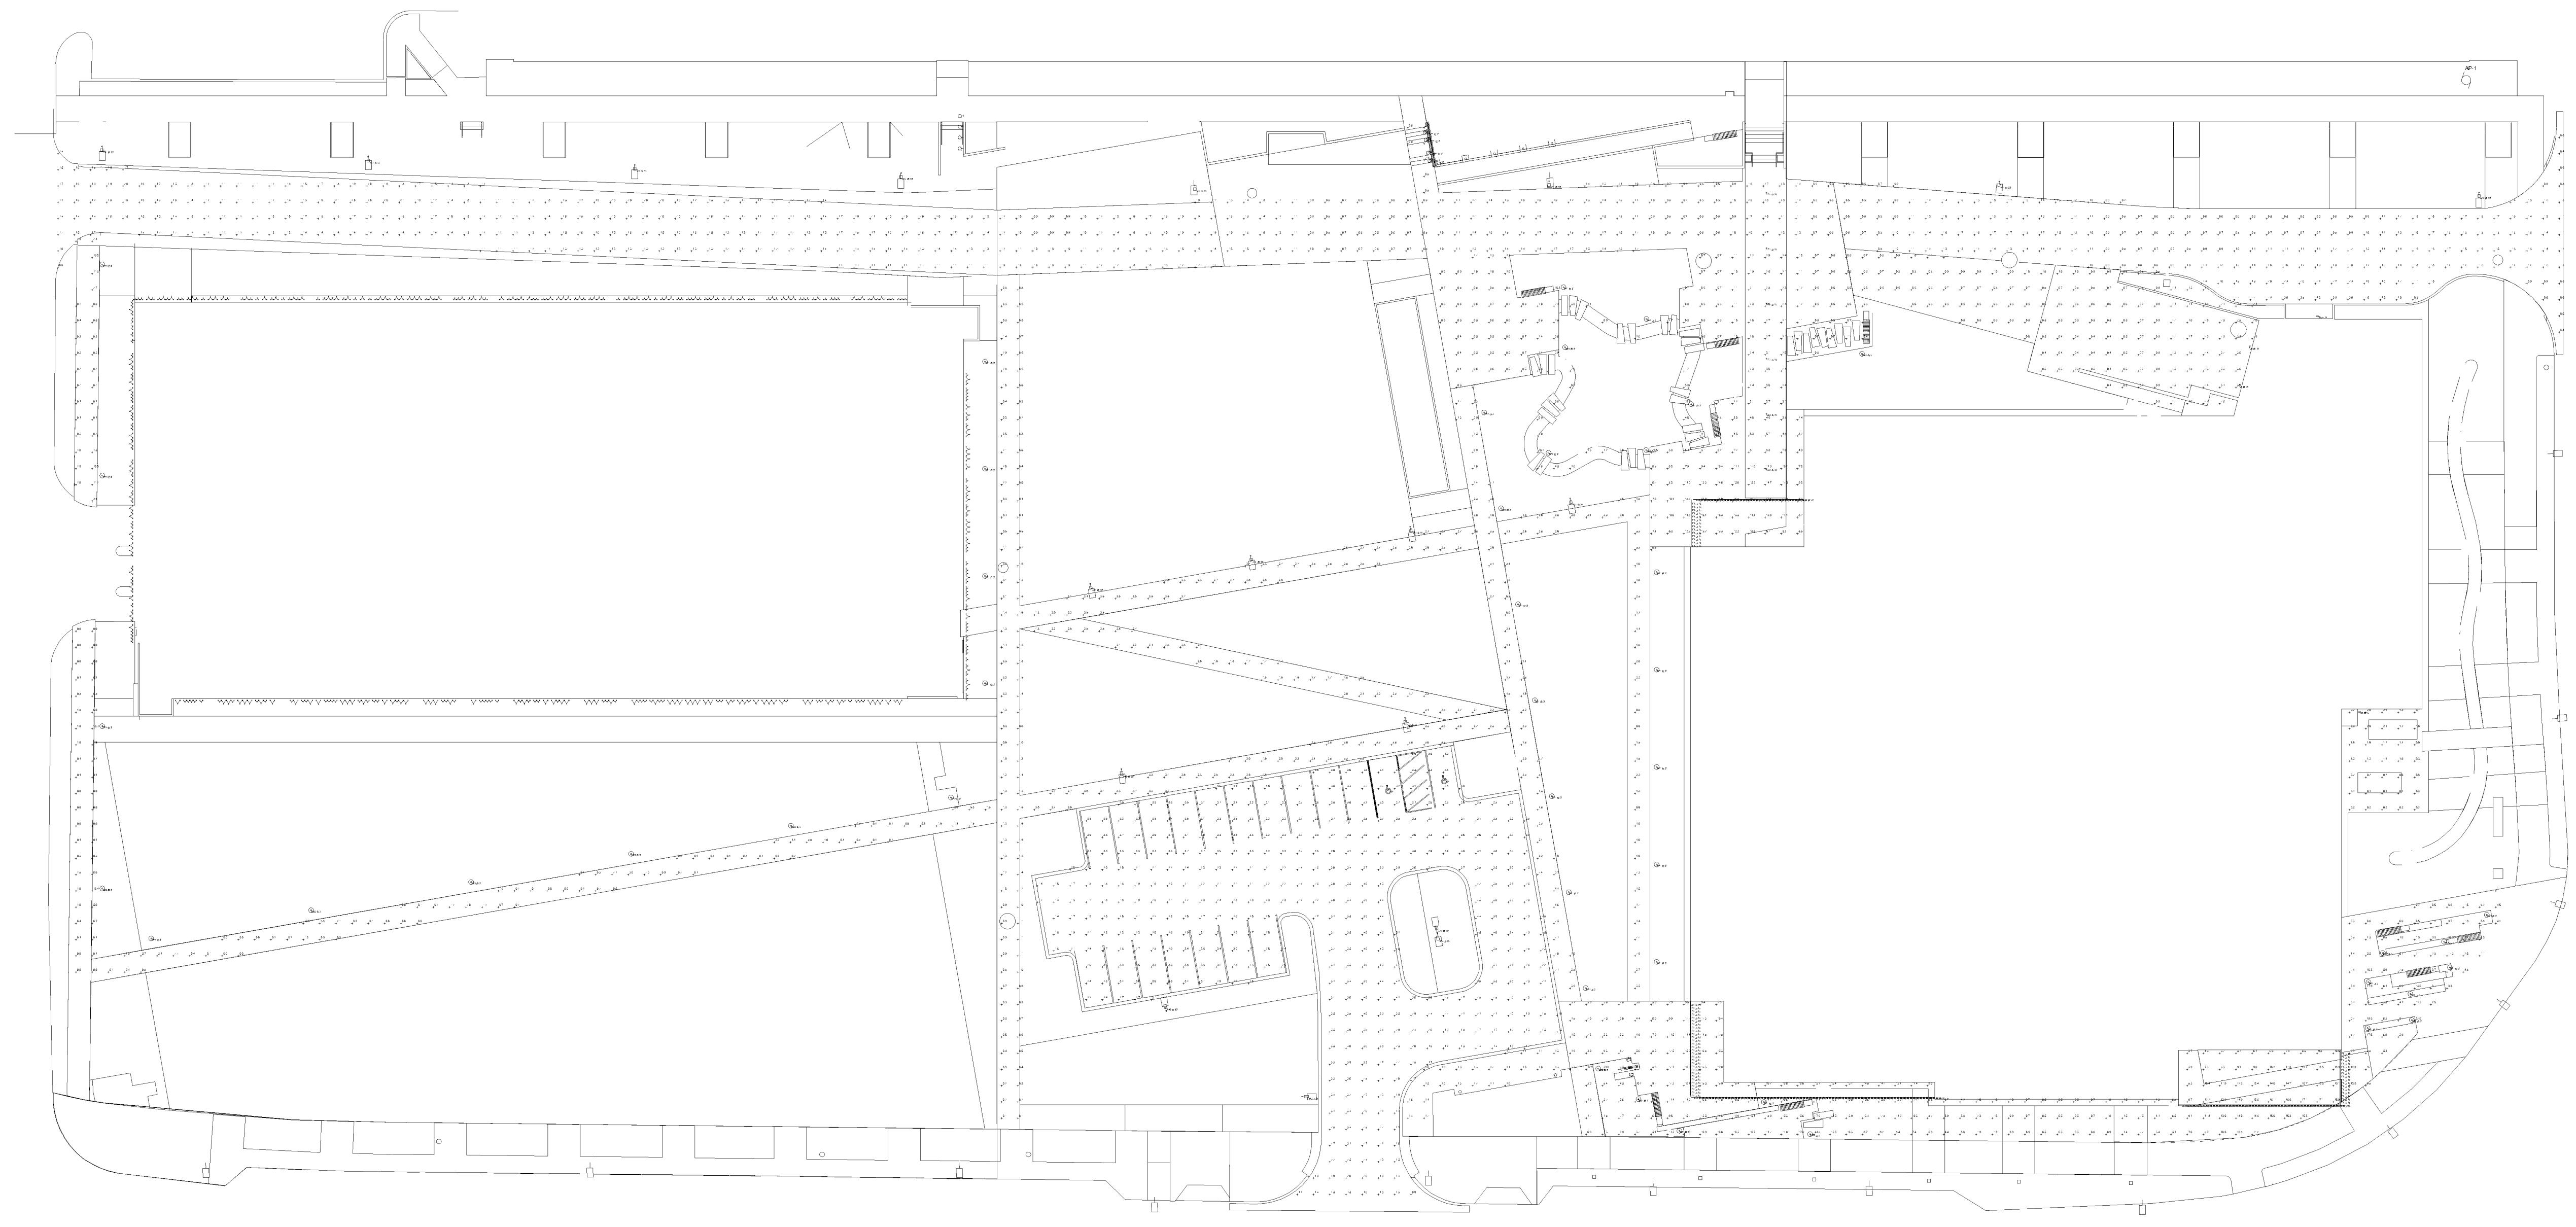

2 SITE PLAN - PHOTOMETRICS - MAINTAINED

SCALE: 1" = 30'-0"

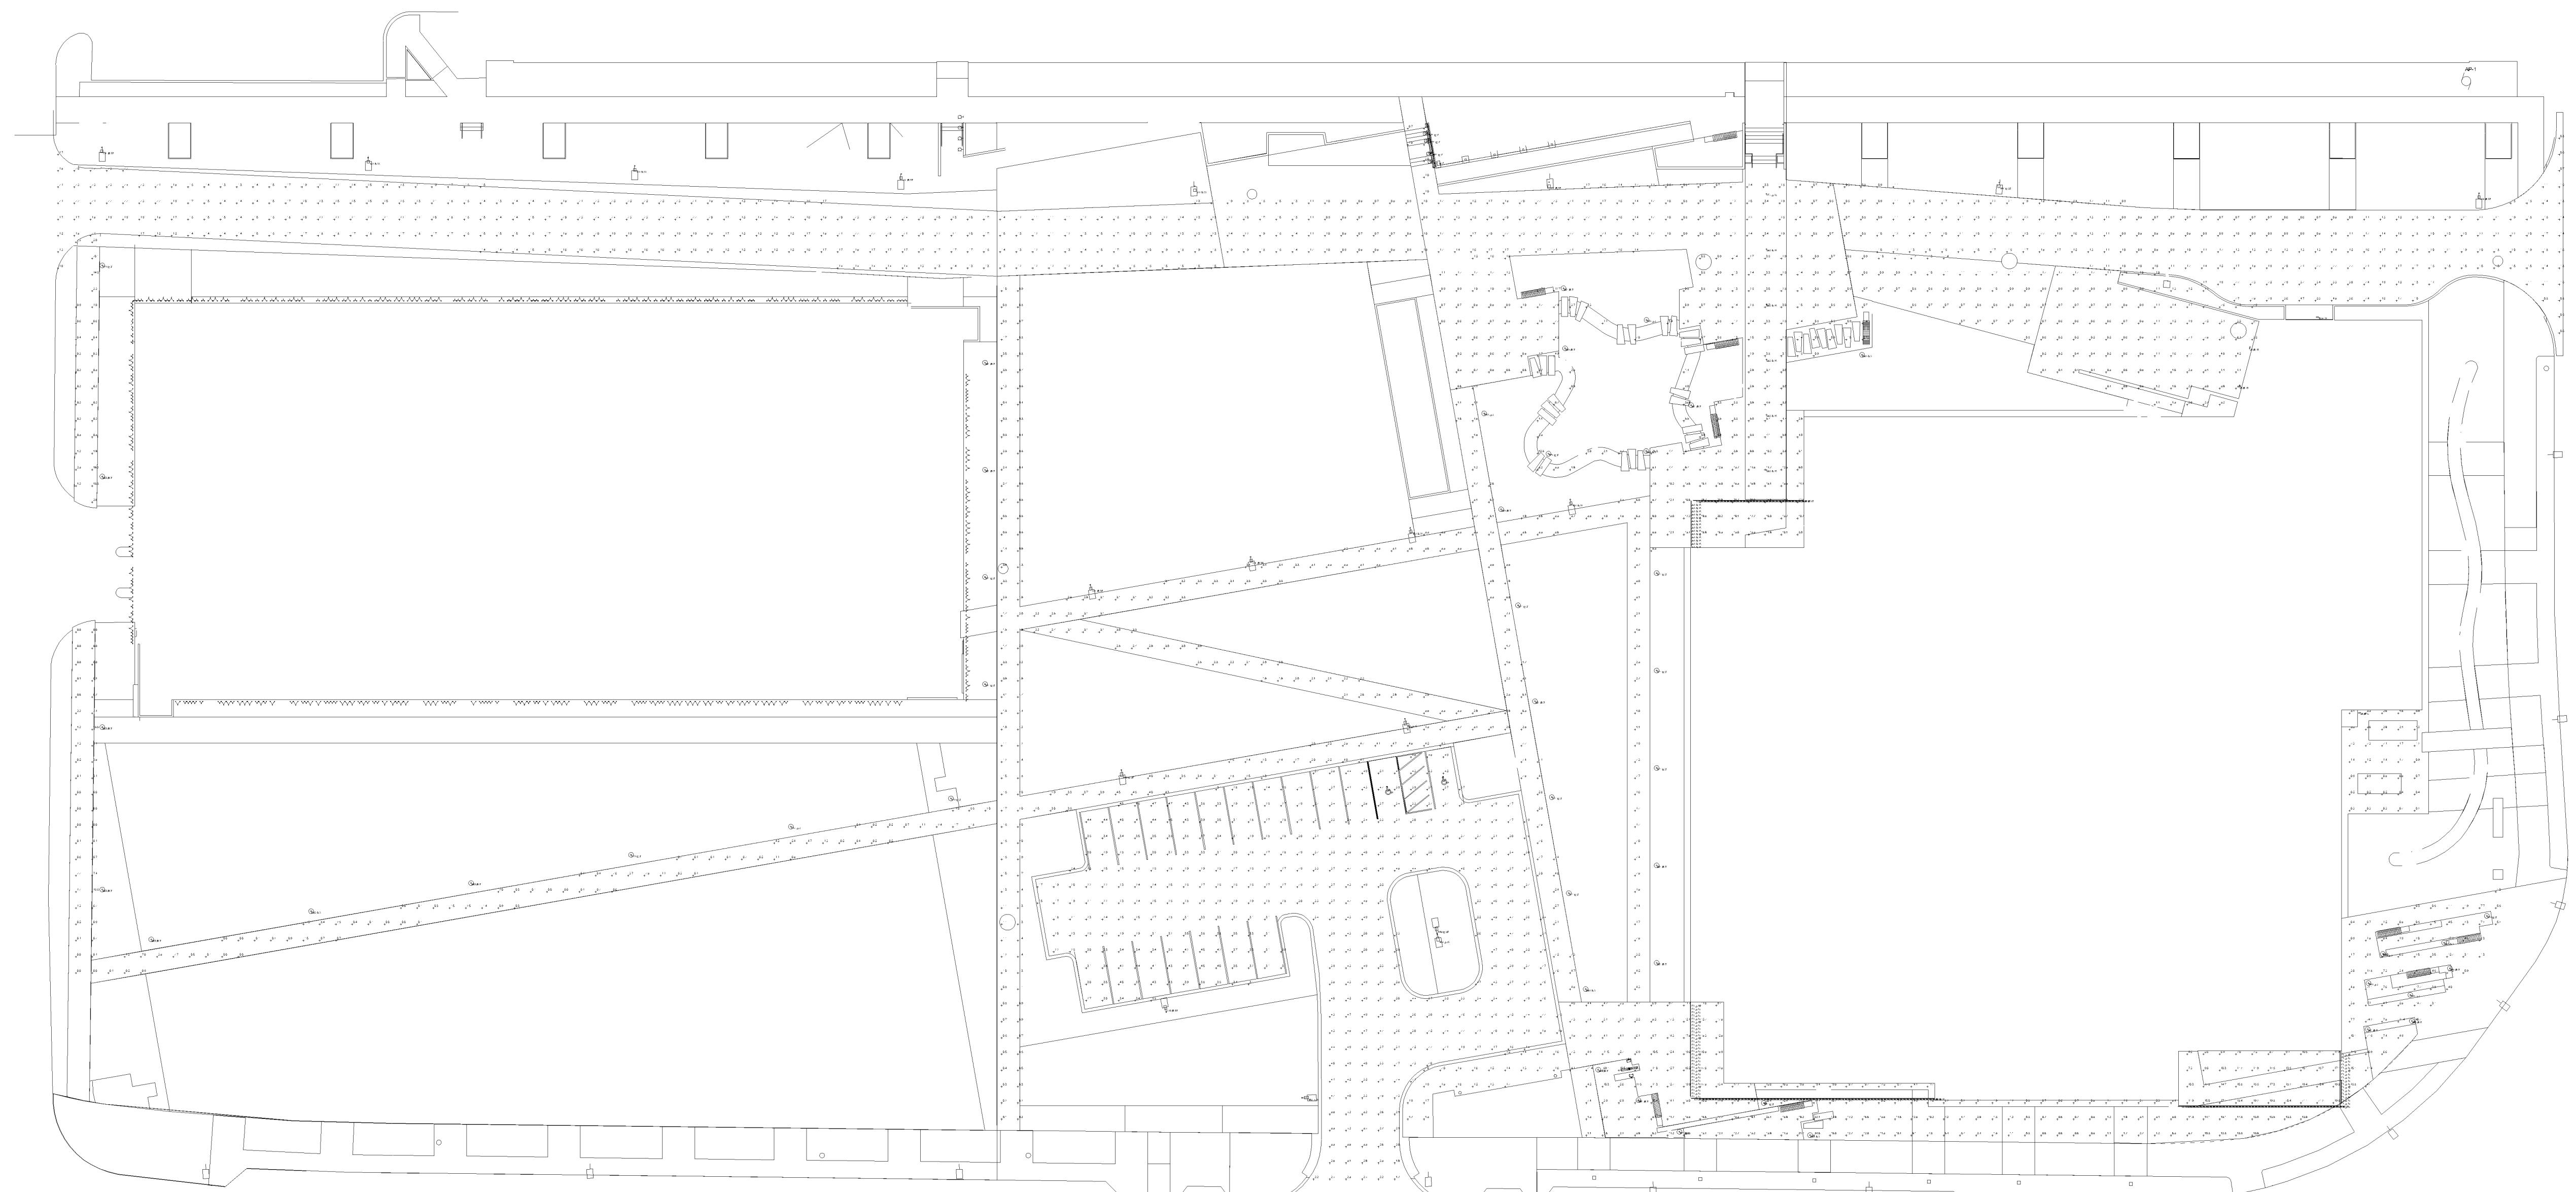

SITE PLAN - PHOTOMETRICS - INITIA

SCALE: 1" = 30'-0"

Approved - Zoning Review

06/04/2024

M. Centinario


reet number
E0.01

PL202300113

CLOW BERG
501 N 3rd Street, Suite 100, Minneapolis, MN 55401 | 612-345-2500


CMTA
A LEGENCE Company
cmta.com | 877 380 0501

Symbol	Label	QTY	Manufacturer	Catalog	Description	Number Lamps	Lamp Output	LLF	Input Power
□	A1	16	Uithoria Lighting	D5X2 LED P3 40K 80CRI T4M	D-Series Site 2 Area Luminaire P3 Performance Package 4000K CCT 80 CRI Type 4 Medium	1	27399	0.81	219.4
○	P1	39	BEACON PRODUCTS	SRT2-BS-4K7-SQW	SRT2 85W SQW DISTRIBUTION 9171 lumens	1	9171	0.81	87.2
—	V3	3	Nulite Lighting	RXT-P-D-FF-09L35-4	3600 lumens	1	3604	0.81	40.558
—	V4	6	Nulite Lighting	RXT-R-D-FF-14L35-4	5700 lumens	1	5474	0.81	53.754

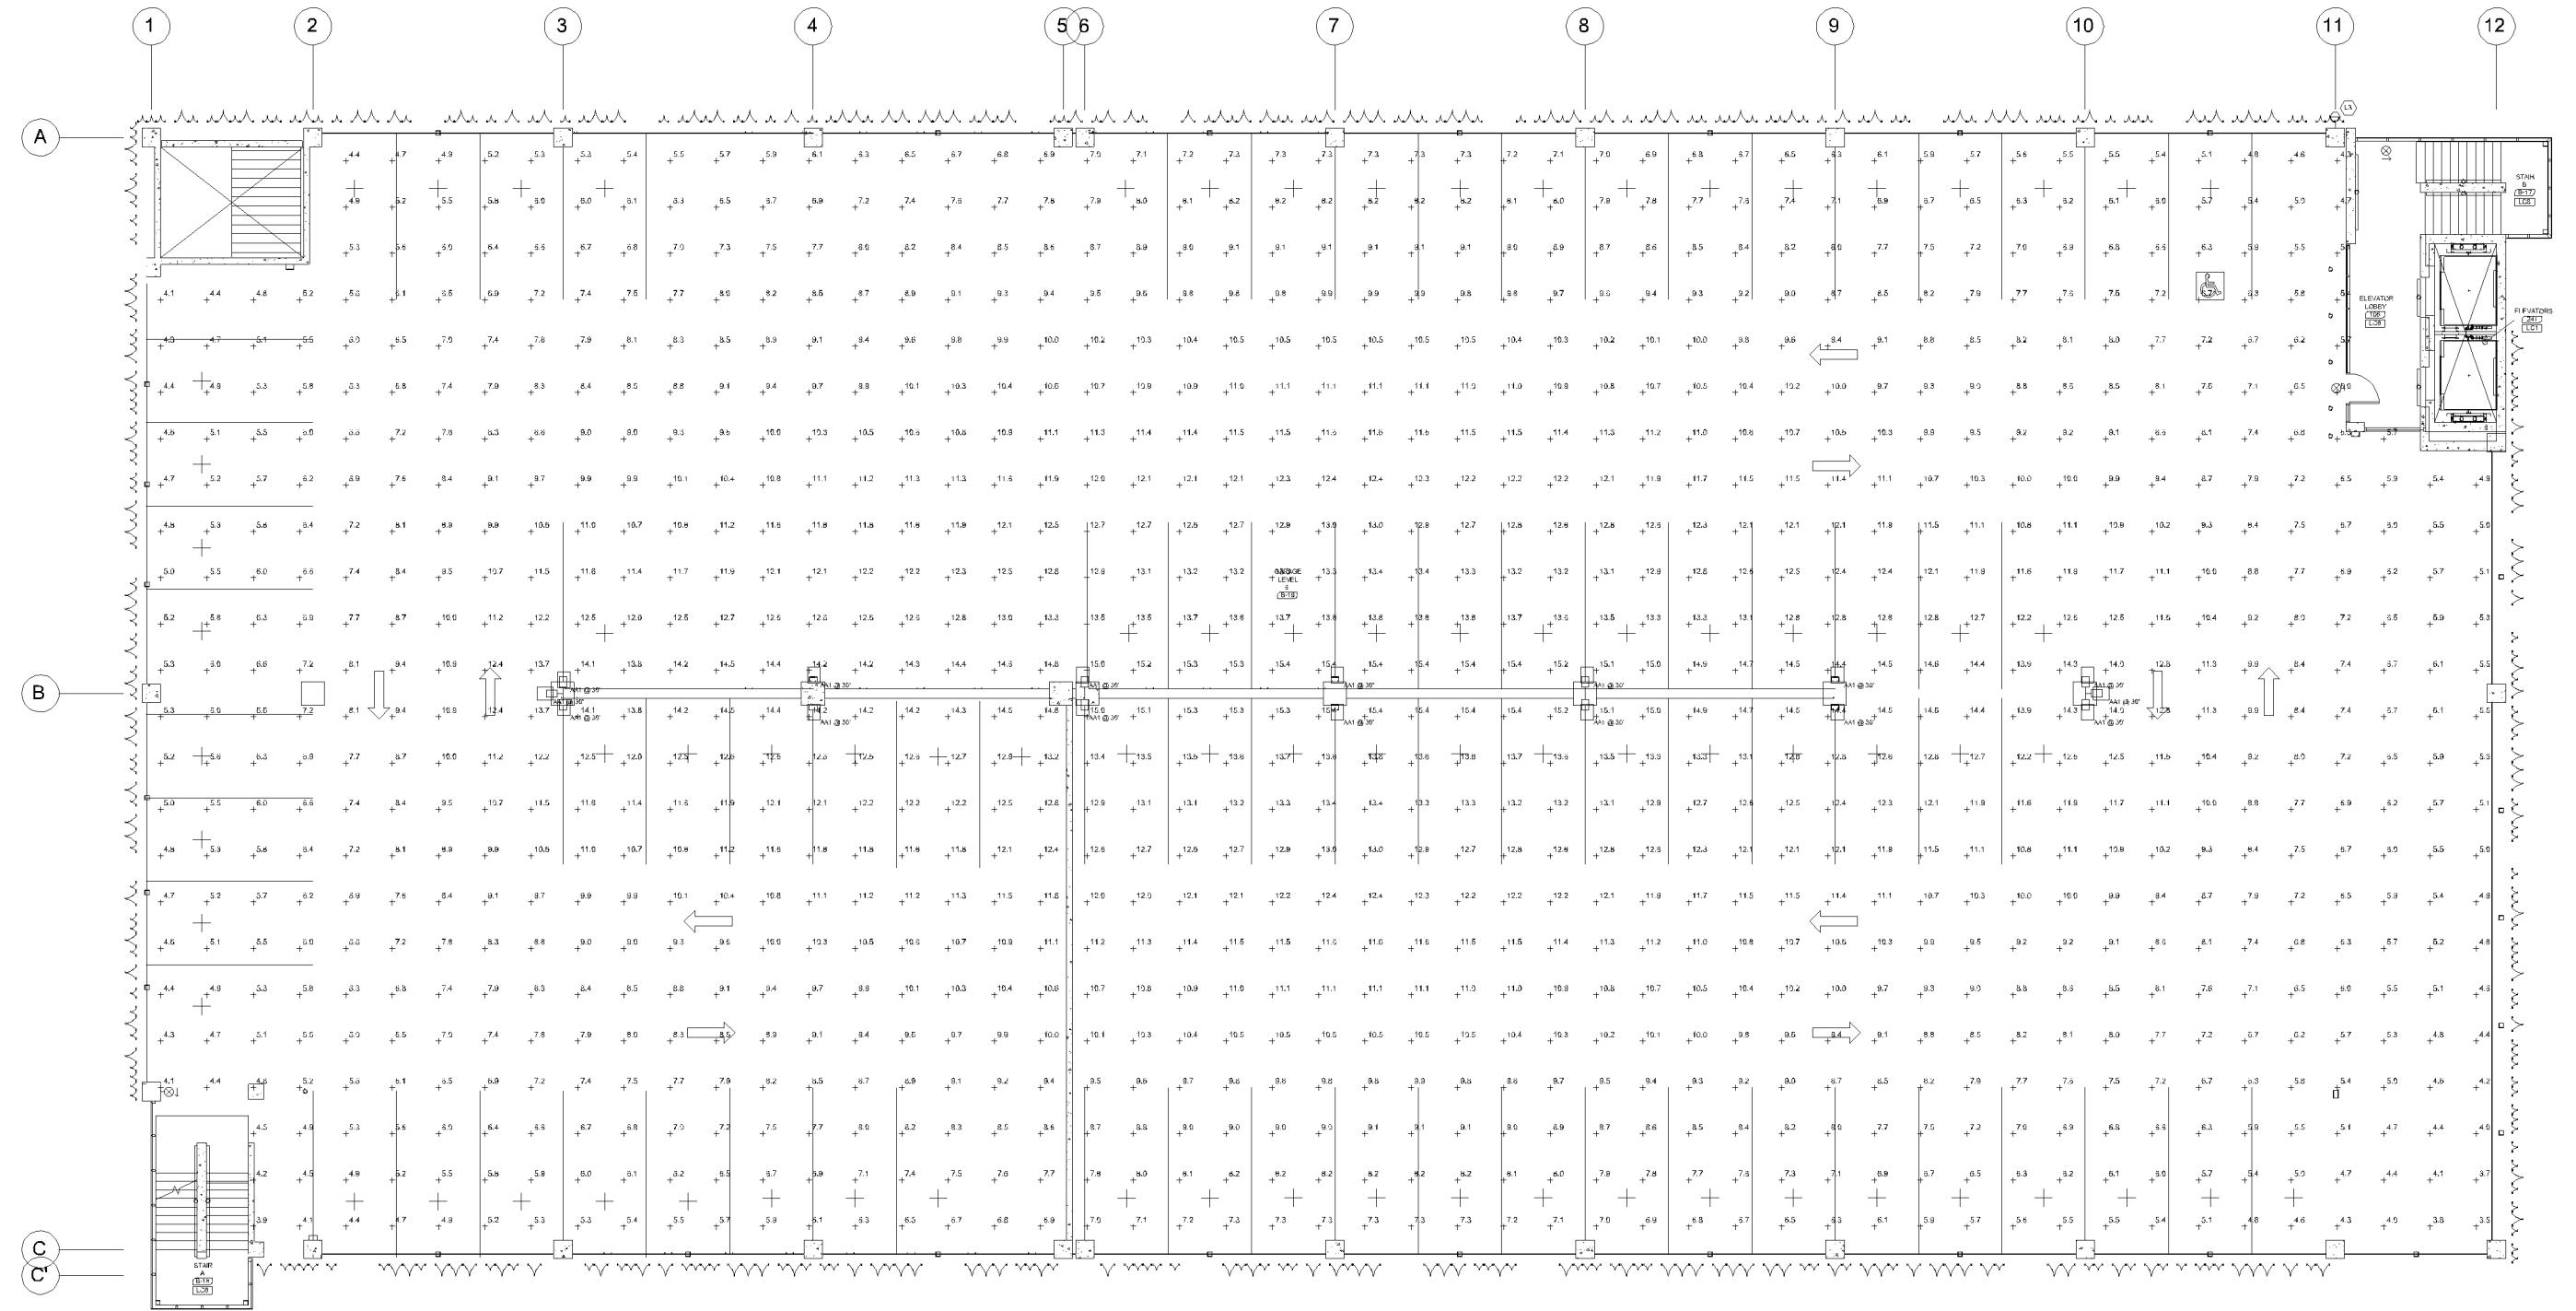


6 LEVEL 6 - PHOTOMETRICS - INITIAL

SCALE: 1" = 20'-0"

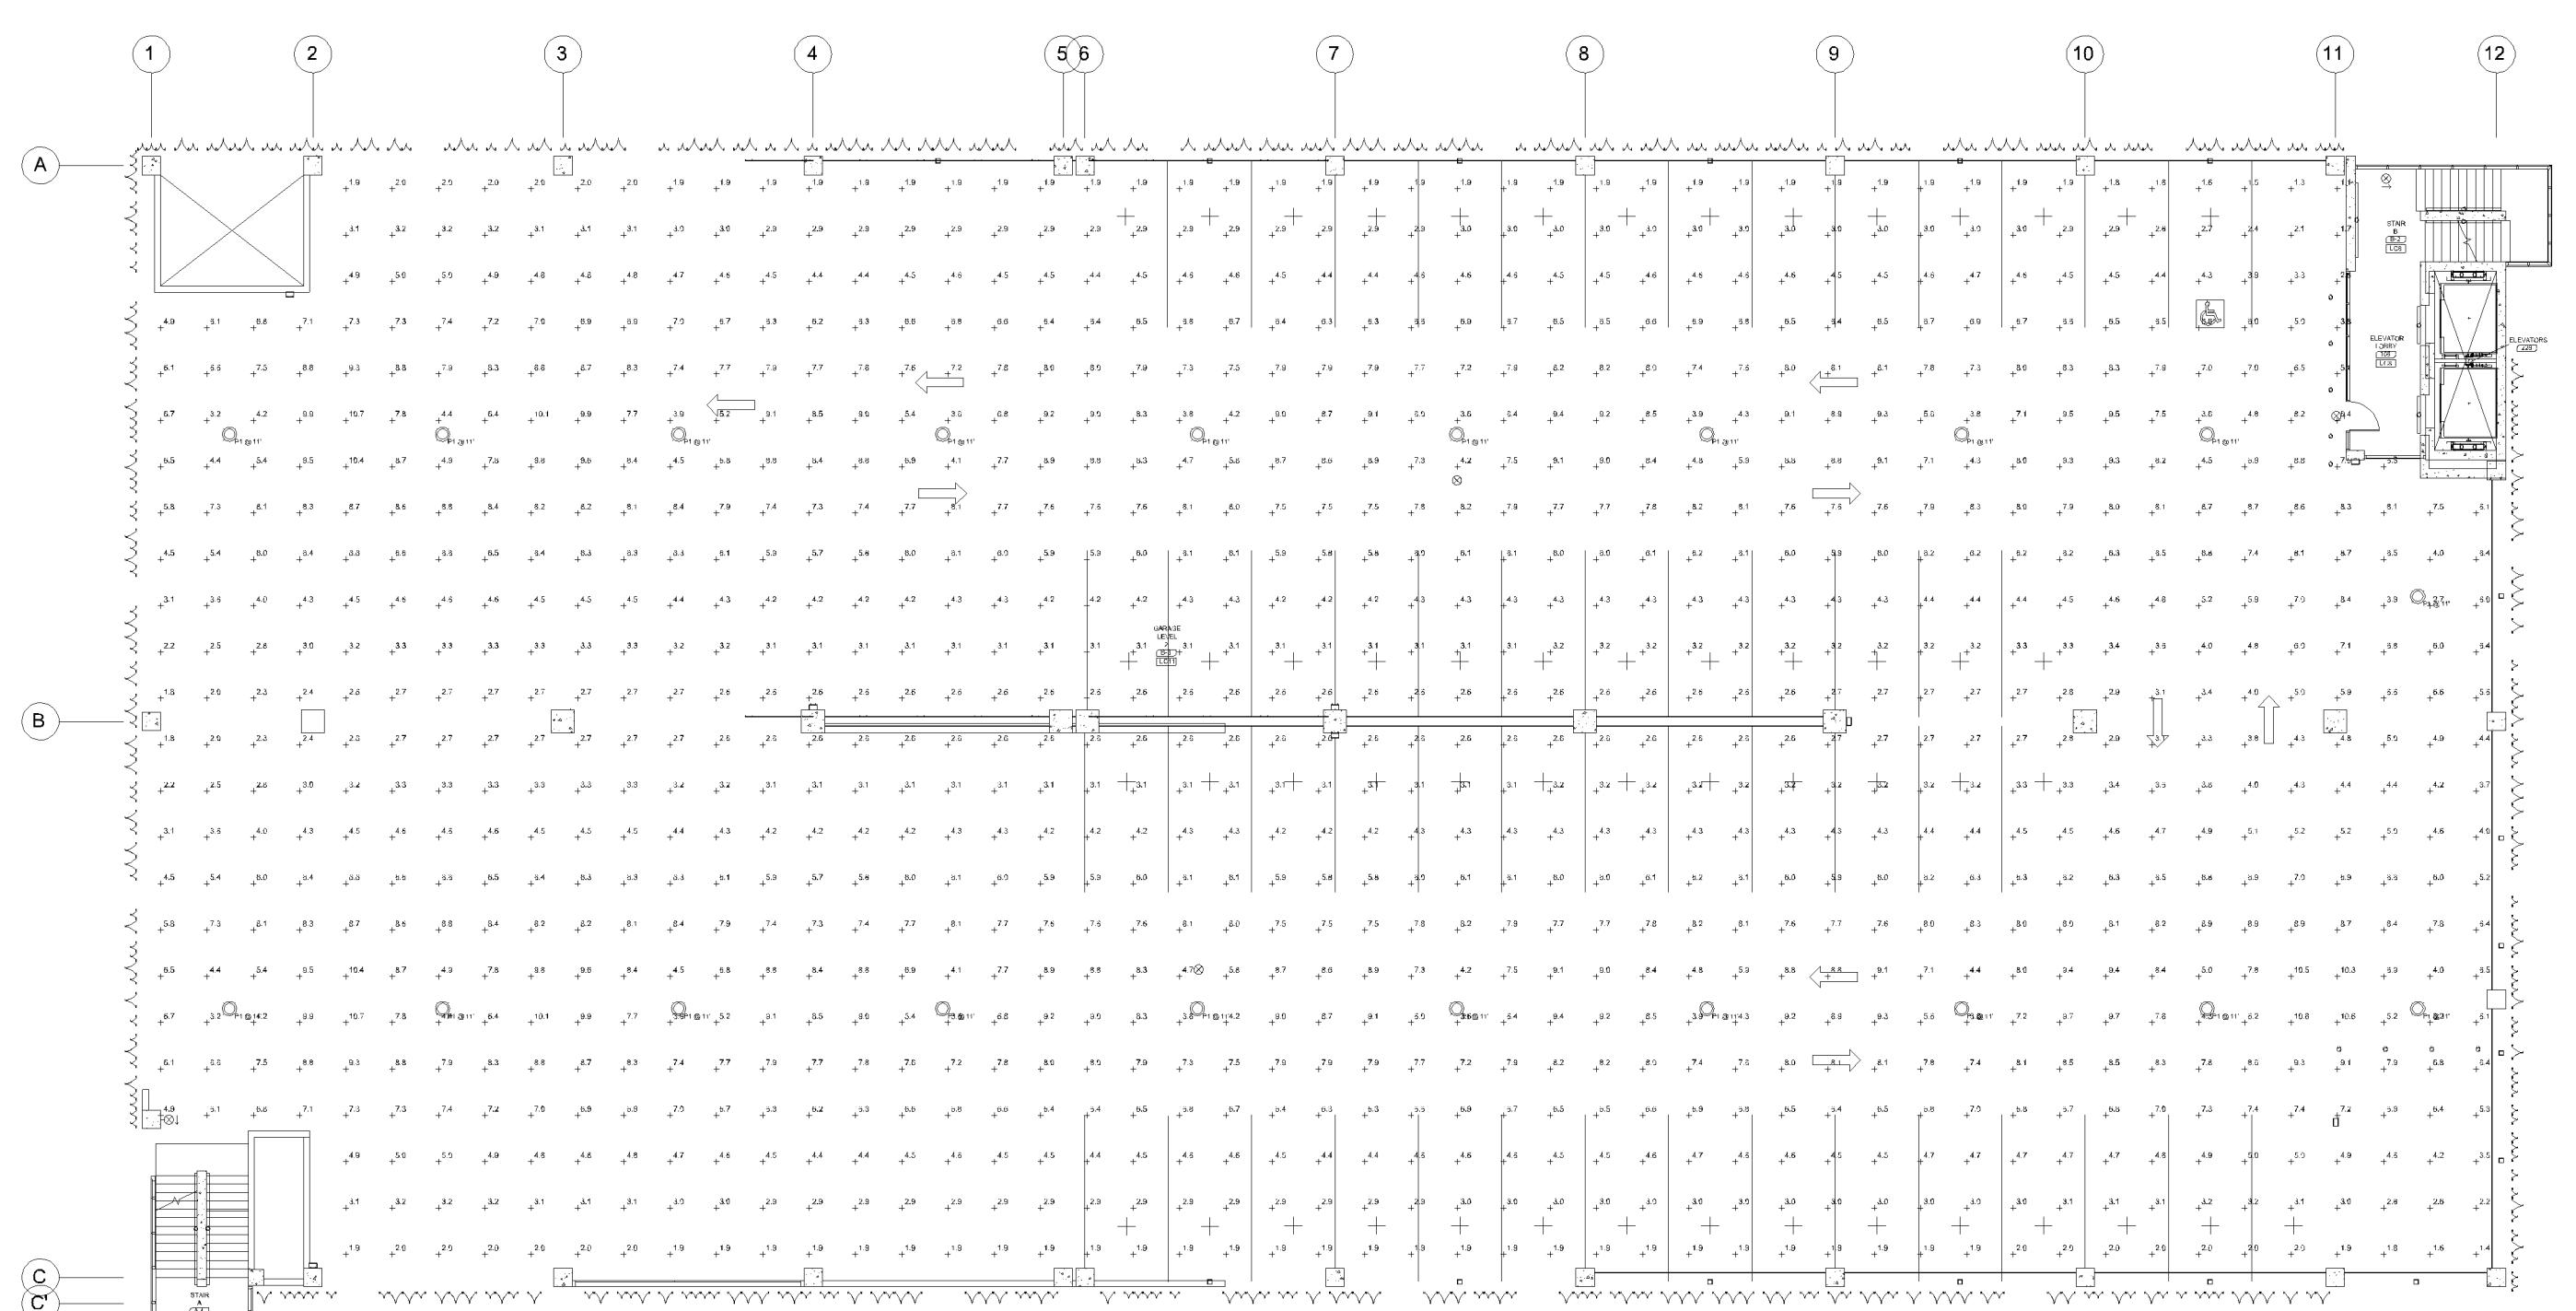


5 LEVEL 2-5 - PHOTOMETRICS - INITIAL

SCALE: 1" = 20'-0"

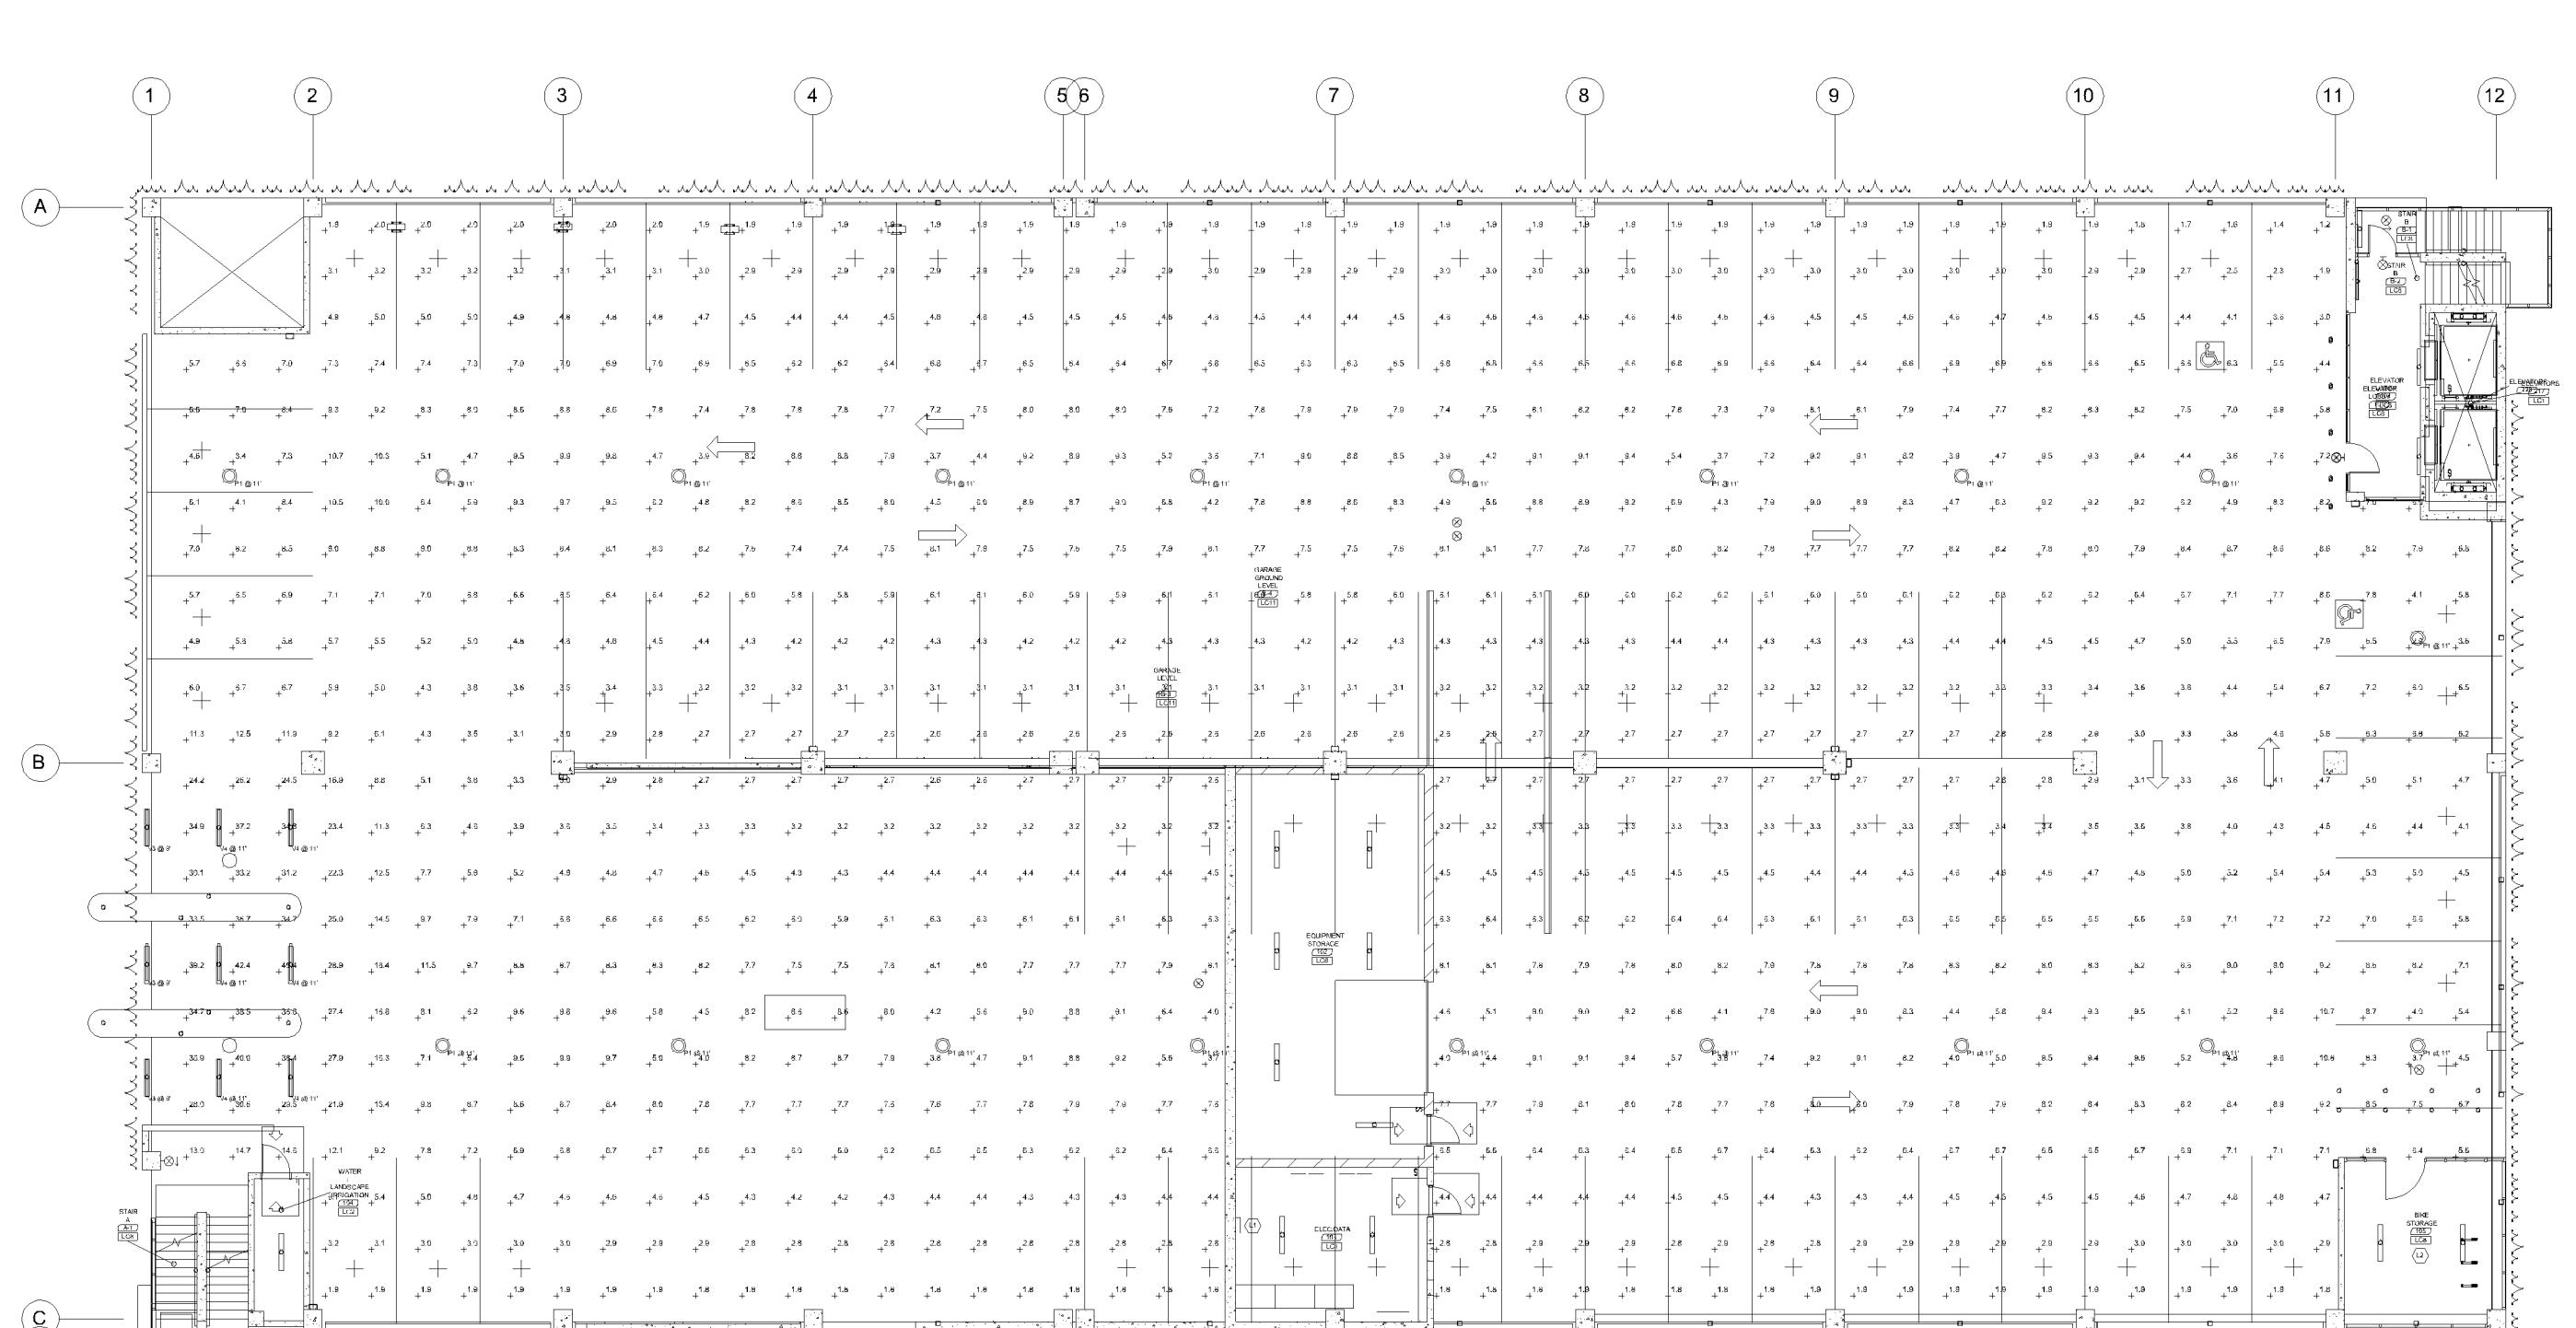


4 GROUND LEVEL - PHOTOMETRICS - INITIAL

SCALE: NTS

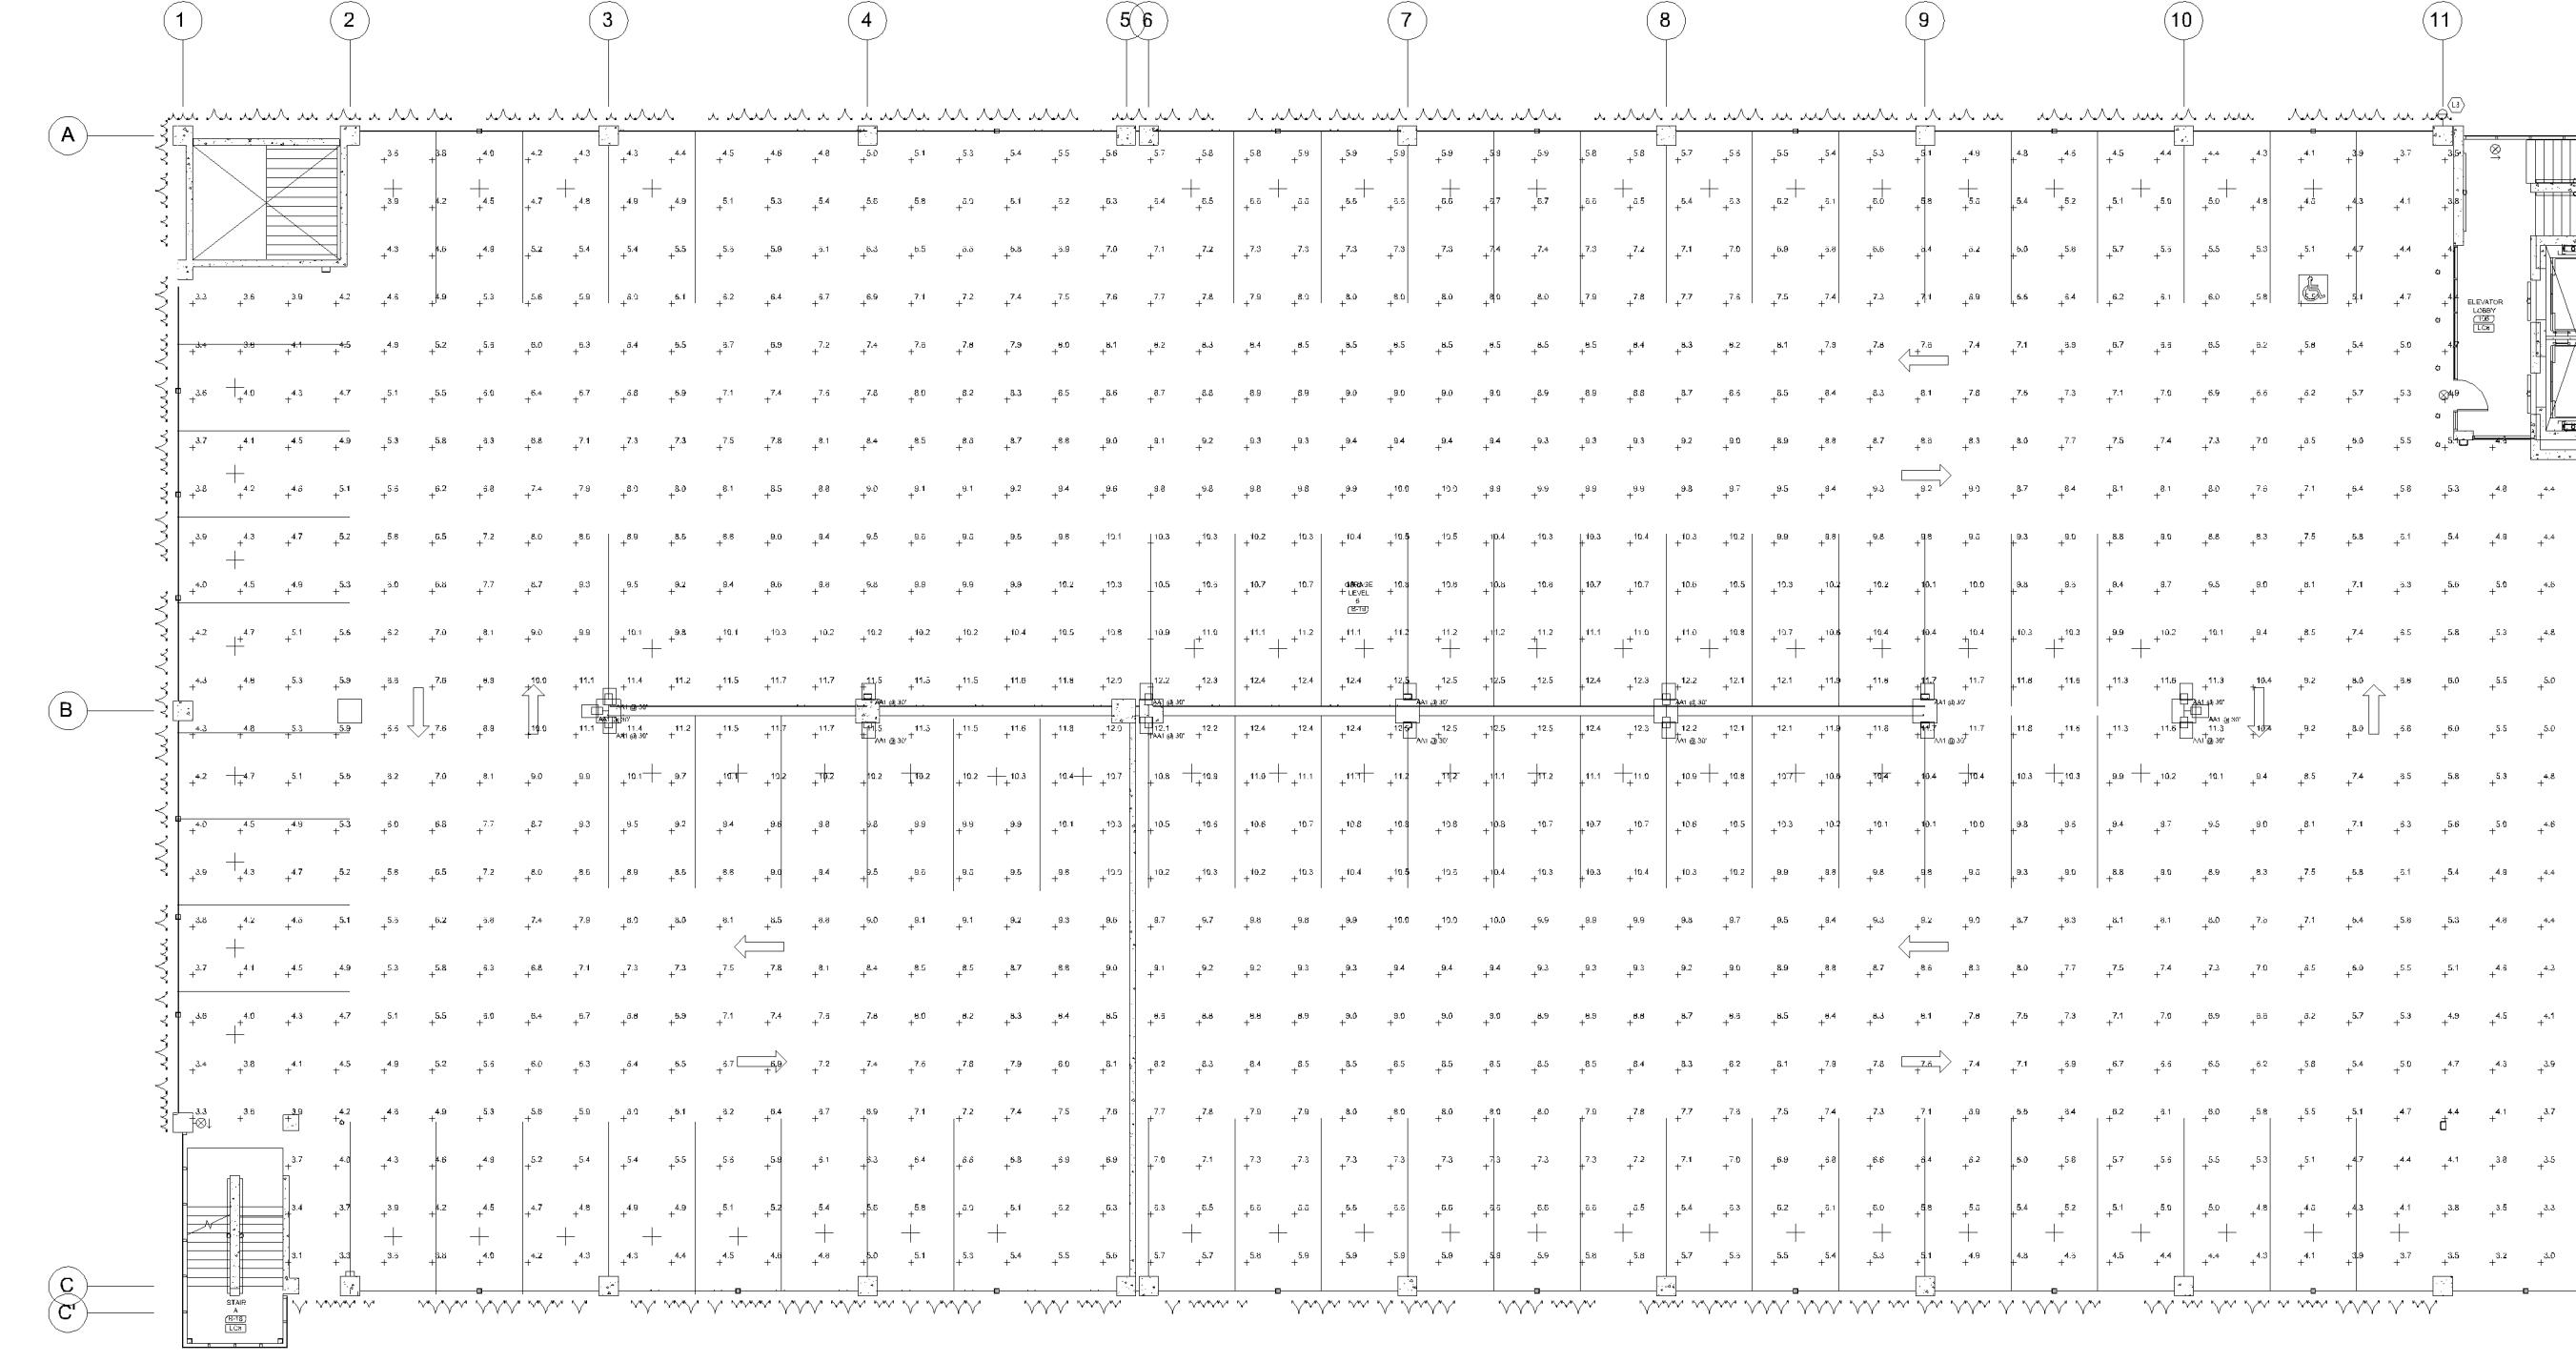


3 LEVEL 6 - PHOTOMETRICS - MAINTAINED

SCALE: NTS

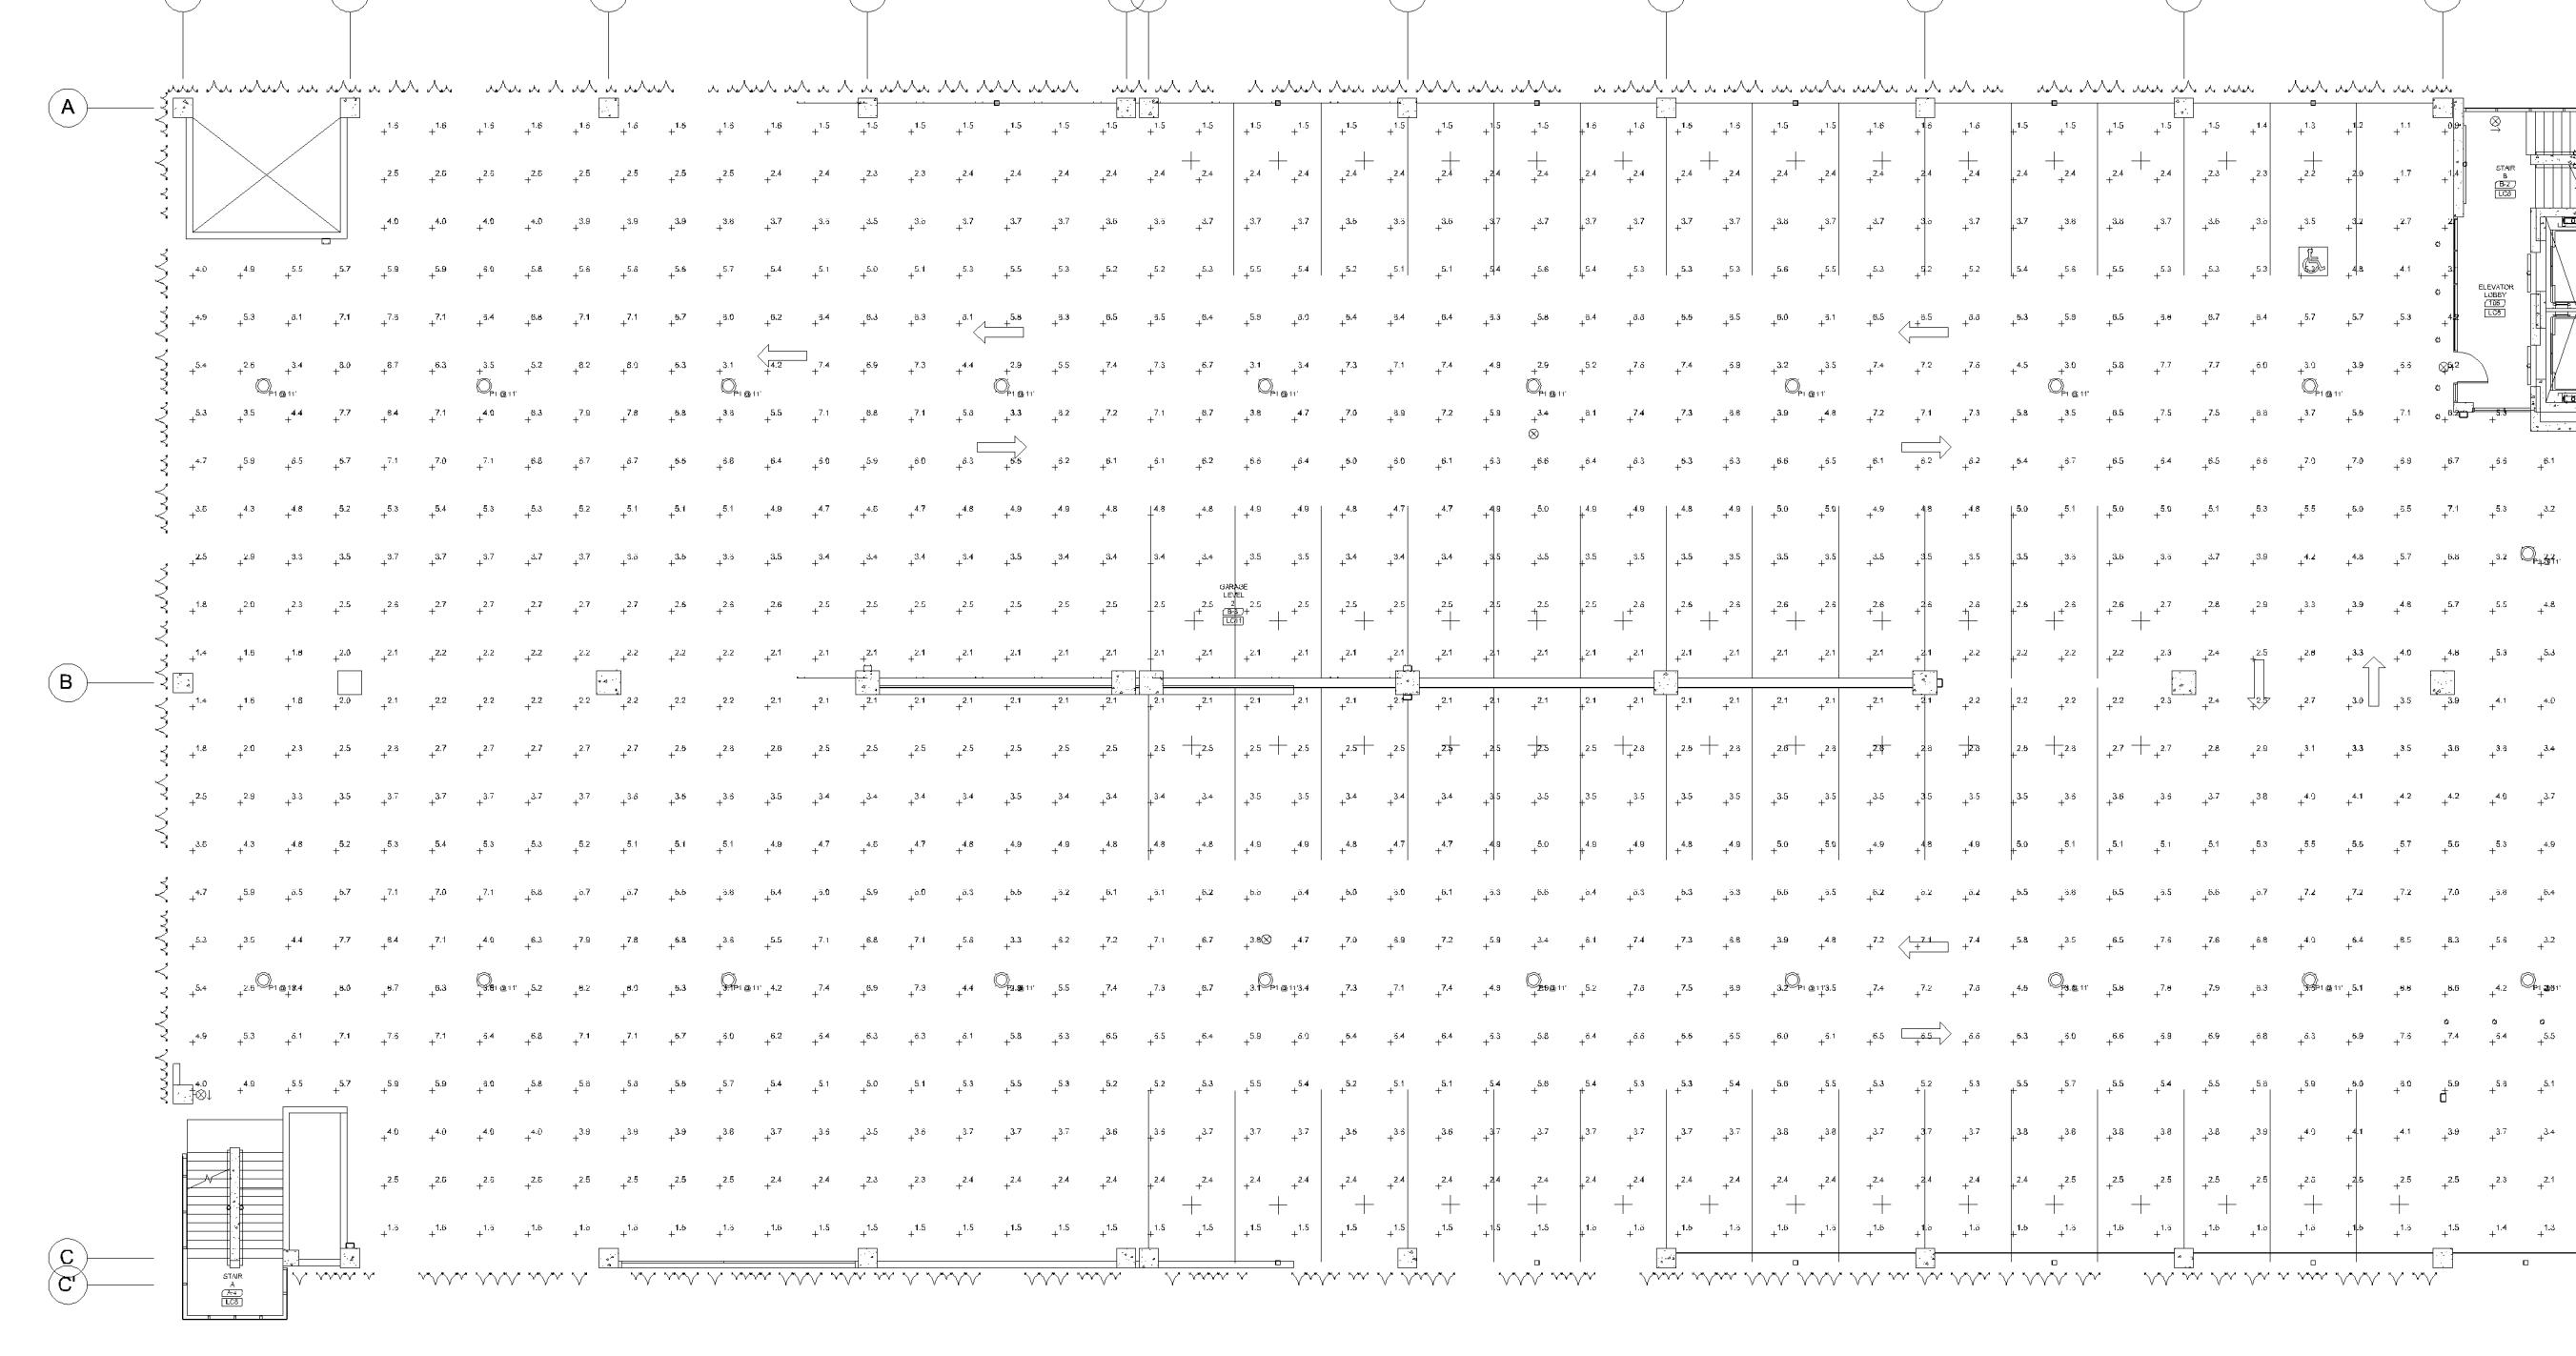

2 LEVEL 2-5 - PHOTOMETRICS - MAINTAINED

SCALE: NTS

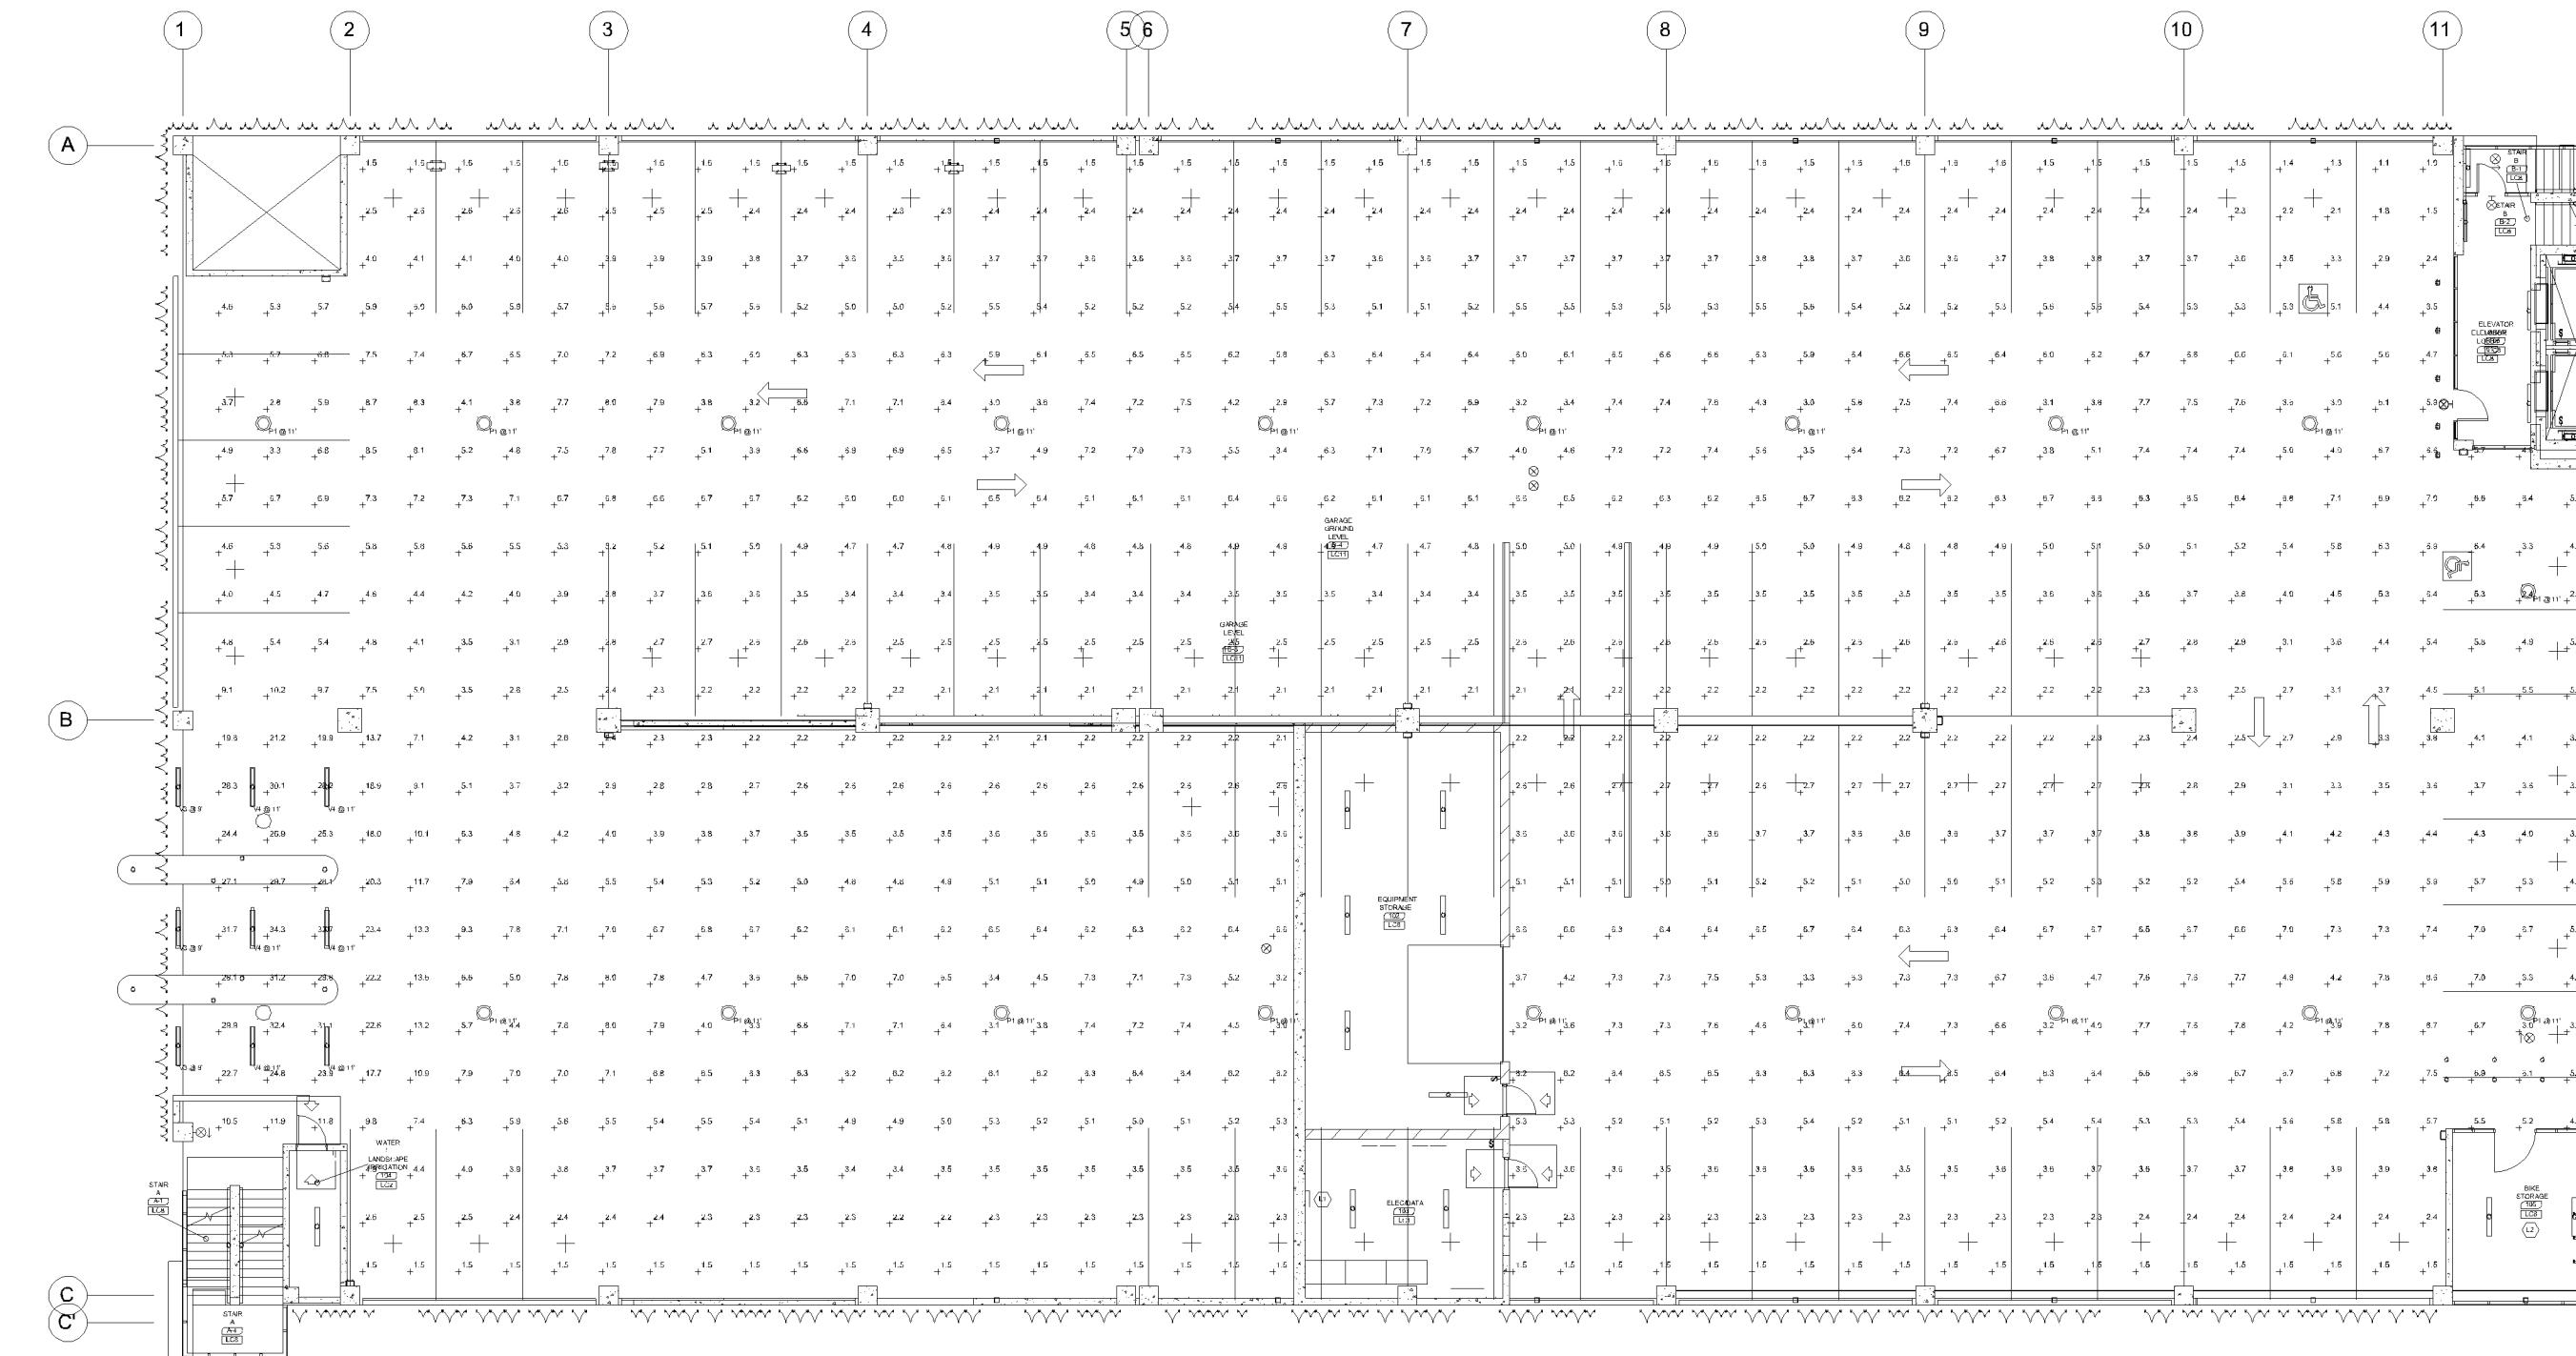

1 GROUND LEVEL - PHOTOMETRICS - MAINTAINED

SCALE: NTS

REVISIONS
NO. DATE DESCRIPTION

I hereby certify that this plan specification, or report was prepared by me or under my direct supervision and is signed by a licensed Professional Engineer under the laws of the state of Minnesota.

Signed: *Josh Ortmann*

Name: **Josh Ortmann**
License No. **5/31/2024**

phase
date
PIC
drawn by
project number
project name

PERMIT SET
2/28/2024
MBS
Author
2022215

BLOOMINGTON
PARKING
STRUCTURE

sheet title
PHOTOMETRICS PLAN

sheet number
E0.01